


Absolent Ductwork Layout Plan View

Note:
For both 4" drops we will cut a 4" hole and attach a 4" angle flange adaptor then a 4" Throttle valve.

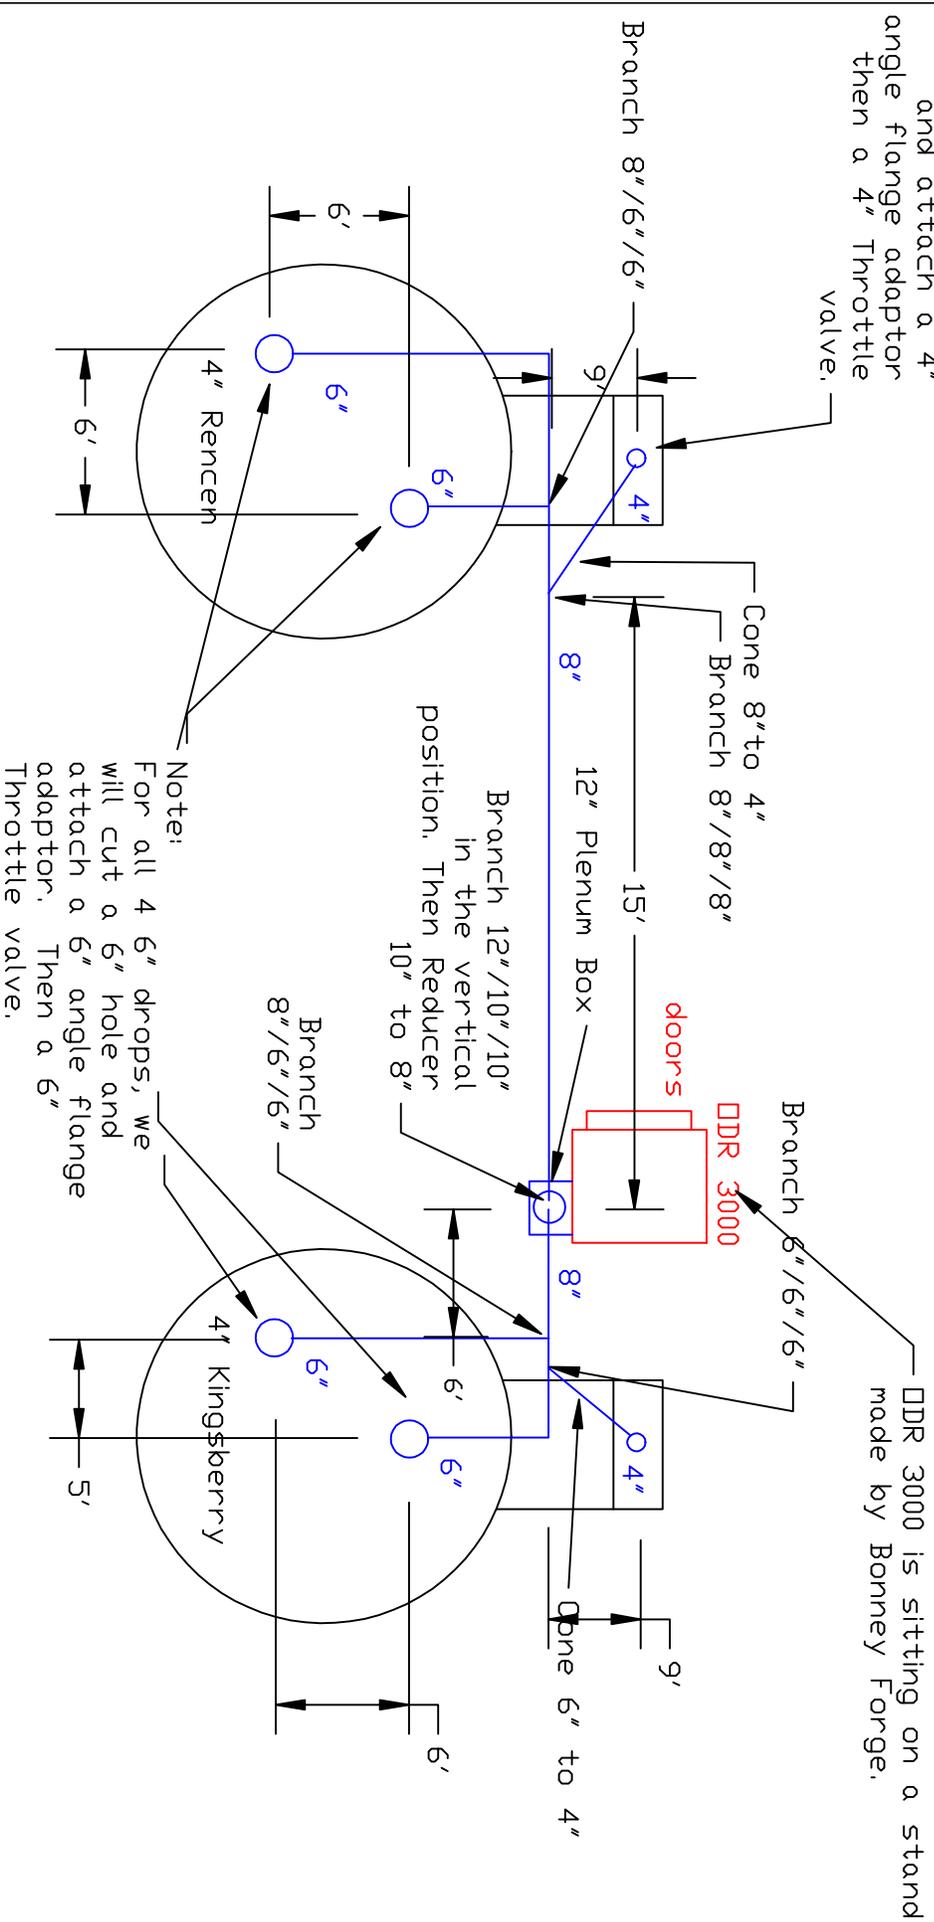

Note:
For all 4 6" drops, we will cut a 6" hole and attach a 6" angle flange adaptor. Then a 6" Throttle valve.

DDR 3000 is sitting on a stand made by Bonney Forge.

Avani Environmental
95 Cypress Drive 27596
Youngsville, NC
PH 919-570-2862 FX 919-570-2863
Avani
Project: Bonney Forge
Drawing: 4" Rencen
Date: 12/10/10 Drawn by: RAV
Sheet No: